



NOTICE: When Government drawings, specifications, or other data are used for any purpose other than in connection with a definitely related Government procurement operation, the United States Government thereby incurs no responsibility for obligation whatsoever and the fact that the Government may have formulated, furnished, or in any way supplied the said drawings, specifications, or other data is not to be regarded as an implication or otherwise as in any manner licensing the holder or any other person or corporation, or conveying any rights or permission to manufacture, use, or sell any patented invention that may in any way be related thereto.

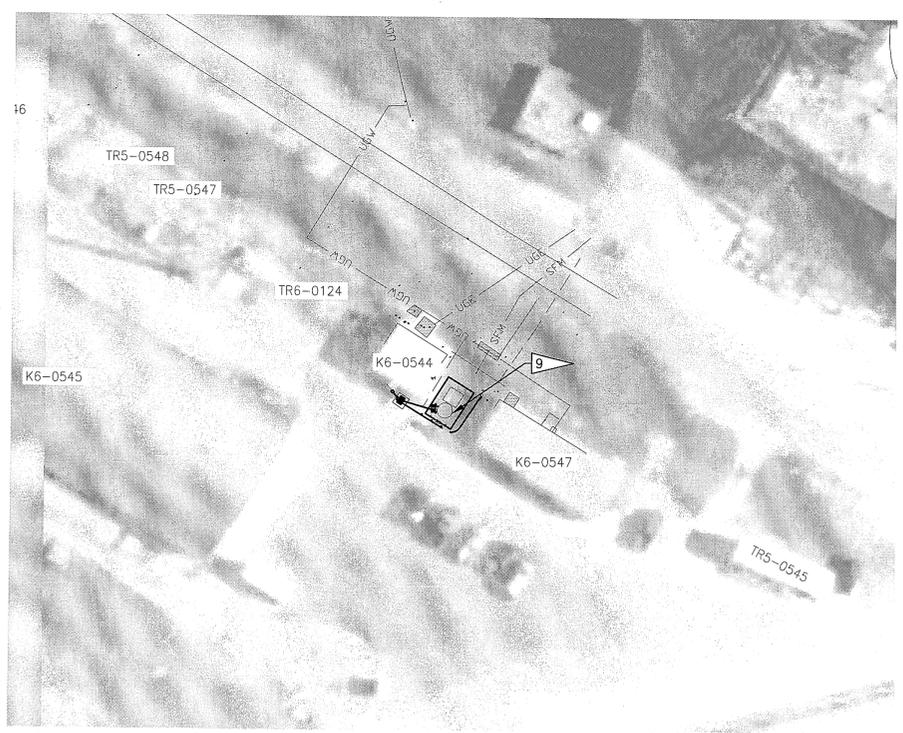

LIFT STATION LS-4K1 PLAN
1"=30'

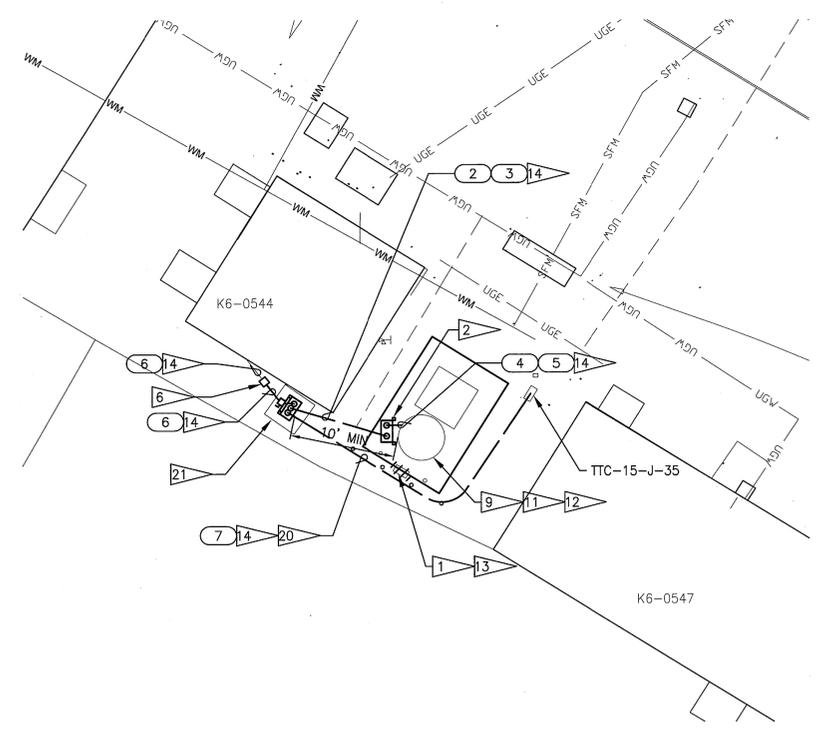


LIFT STATION LS-4K1 PLAN
1"=10'




LIFT STATION LS-4K1
NTS



LIFT STATION LS-4L PLAN
1"=30'



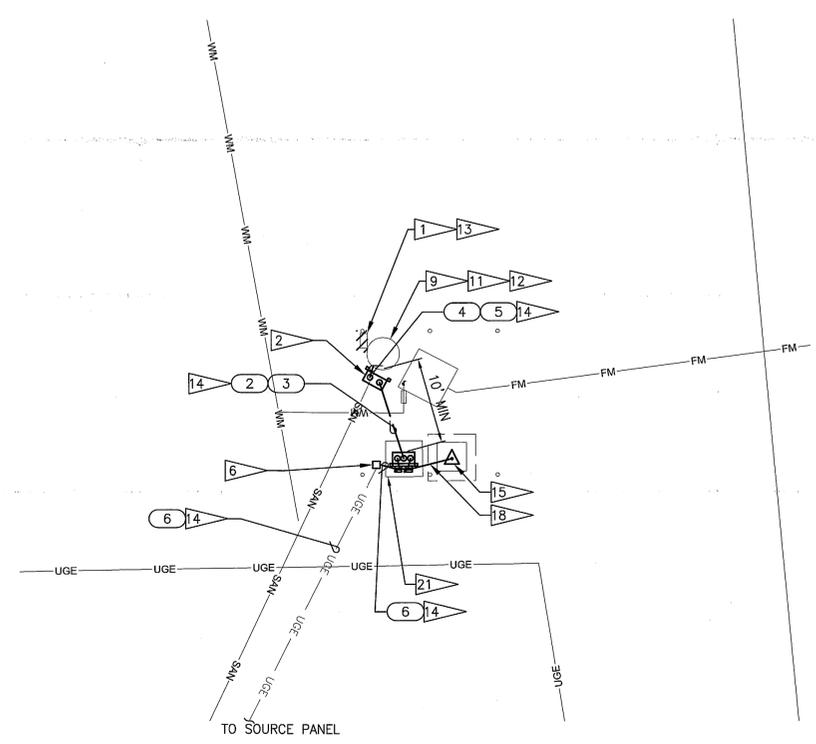


LIFT STATION LS-4L PLAN
1"=10'

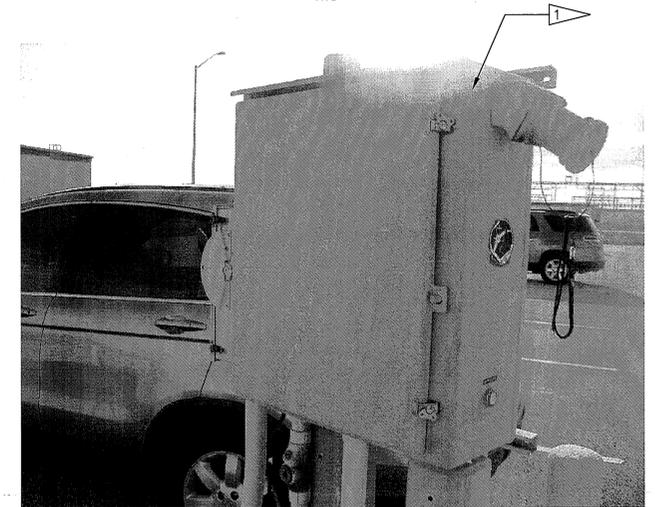


LIFT STATION LS-4L
NTS

 120V POWER 2#12, 1#12 G,
3/4" C, PROVIDE 20A, 1P
BREAKER AT PANEL P-3

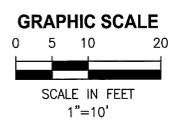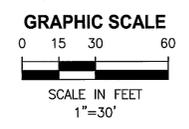


A		GENERAL REVISIONS		10/31/11	<i>[Signature]</i>
SYM	ZONE	DESCRIPTION	DATE	APPROVED	
REVISIONS					
THIS DRAWING CREATED IN AUTOCAD 2010 FILE FORMAT AND WILL BE REVISED ONLY ON AN AUTOCAD SYSTEM. FILE: 14000189-DP2-E18.DWG					
JONES EDMUNDS					
CERTIFICATE OF AUTHORIZATION #1841 730 NE WALDO ROAD, GAINESVILLE, FLORIDA 32641 / (352) 377-5821 3910 S WASHINGTON AVE, SUITE 210, TITUSVILLE, FLORIDA 32780 / (321) 269-2950					
SIGNATURES		DATE		NATIONAL AERONAUTICS AND SPACE ADMINISTRATION JOHN F. KENNEDY SPACE CENTER, NASA KENNEDY SPACE CENTER, FLORIDA	
DRAWN L. MILLER		10/31/11		REVITALIZE WATER & WASTEWATER SYSTEMS - VOLUME 2 OF 5 LIFT STATIONS LIFT STATIONS 4K1 AND 4L ELECTRICAL PLANS	
CHECKED M. KOROS		10/31/11			
SUBMITTED K. CLARK		10/31/11			
ST of LICENSE: FL		LICENSE NO: 48898			
APPROVED K. CLARK		10/31/11			
APPROVED D. TRANG		11/1/11		FILE NO.	SIZE F
E18		DWG. NO. 79K38877 VOL 2		REV A	PROJ. NO. 96966.3
				SHEET 61	


NOTICE: When Government drawings, specifications, or other data are used for any purpose other than in connection with a definitely related Government procurement operation, the United States Government thereby incurs no responsibility nor obligation whatsoever, and the fact that the Government may have formulated, furnished, or in any way supplied the said drawings, specifications or other data is not to be regarded as an implication or otherwise as in any manner licensing the holder or any other person or corporation, or conveying any rights or permission to manufacture, use, or sell any patented invention that may in any way be related thereto.

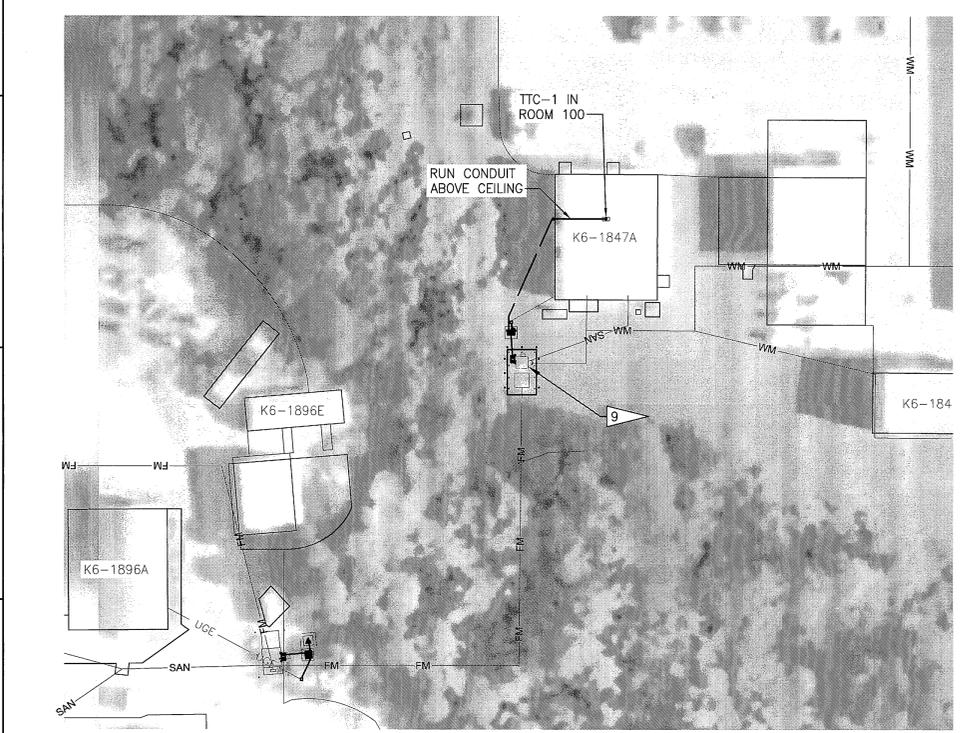


LIFT STATION LS-4N5 PLAN
1"=30'

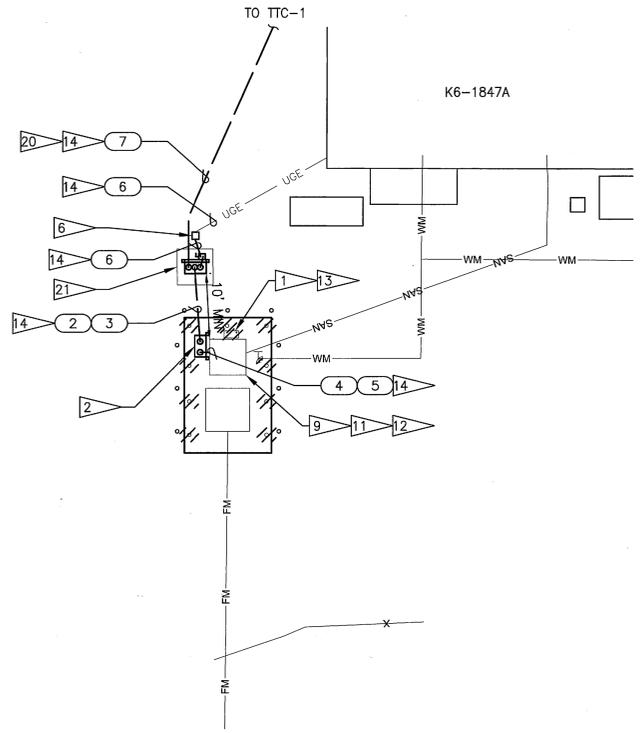


LIFT STATION LS-4N5 PLAN
1"=10'

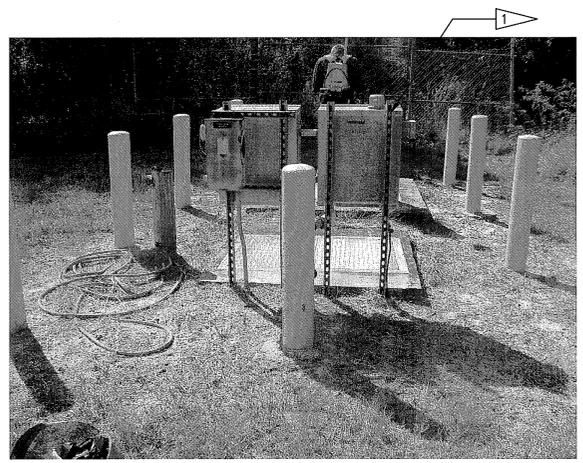


LIFT STATION LS-4N5 PHOTO
NTS

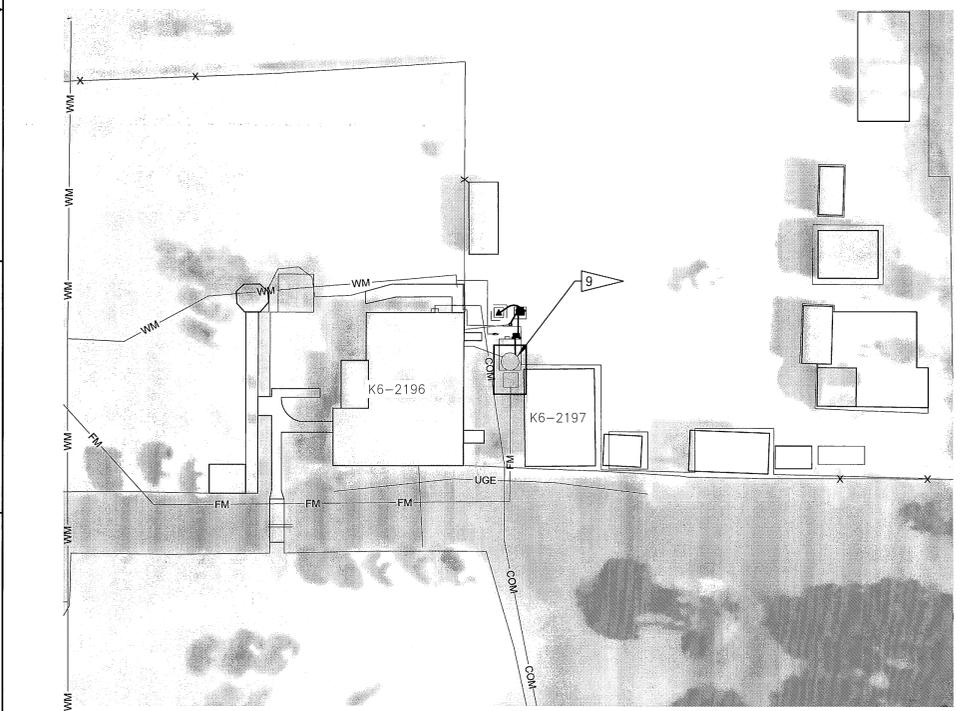




LIFT STATION LS-4N6 PLAN
1"=30'

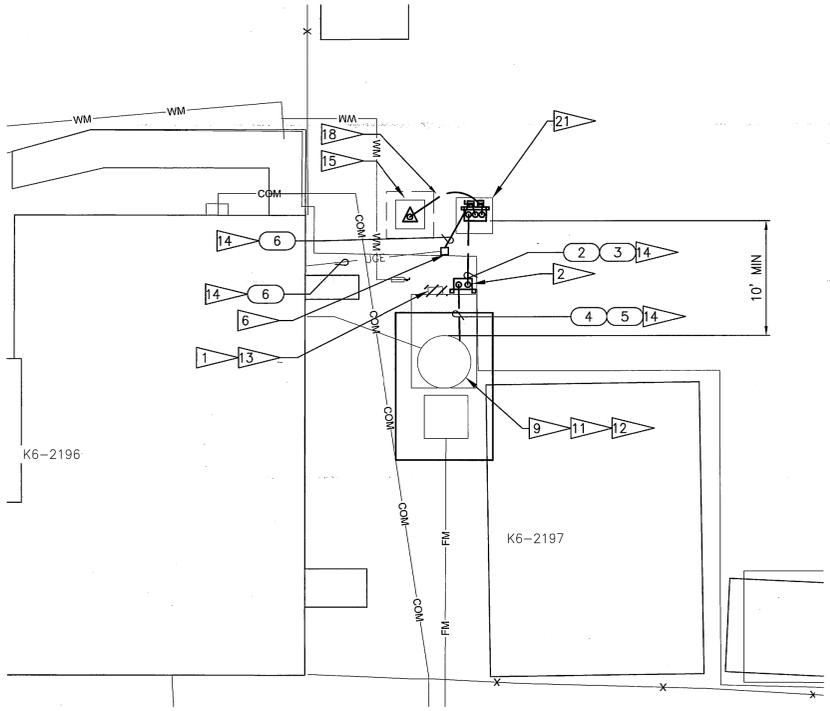

LIFT STATION LS-4N6 PLAN
1"=10'

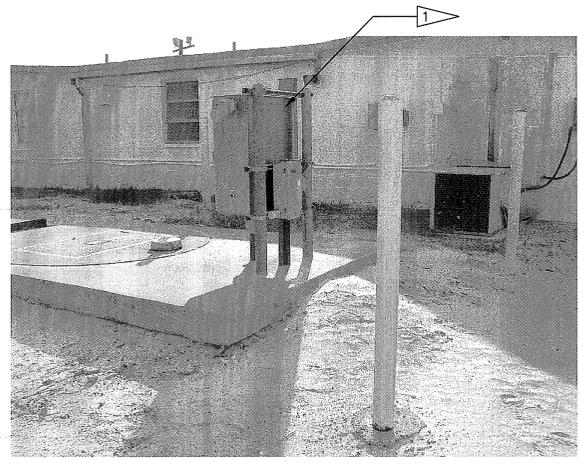


LIFT STATION LS-4N6 PHOTO
NTS

   


A		GENERAL REVISIONS		10/31/11	<i>KM</i>
SYM	ZONE	DESCRIPTION	DATE	APPROVED	
REVISIONS					
THIS DRAWING CREATED IN AUTOCAD 2010 FILE FORMAT AND WILL BE REVISED ONLY ON AN AUTOCAD SYSTEM. FILE: 14000189-DP2-E19.DWG					
JONES EDMUNDS					
<small>CERTIFICATE OF AUTHORIZATION #1841 730 NE WALDO ROAD, GAINESVILLE, FLORIDA 32641 / (352) 377-5821 3910 S WASHINGTON AVE, SUITE 210, TITUSVILLE, FLORIDA 32780 / (321) 269-2950</small>					
SIGNATURES		DATE			
DRAWN L MILLER		10/31/11			
CHECKED M KOROS		10/31/11			
SUBMITTED M CLARK		10/31/11			
STATE OF FLORIDA LICENSE NO: 48898					
APPROVED <i>[Signature]</i>		10/31/11			
E19		FILE NO.		SIZE	REV
		79K38877 VOL 2		F	A
		PROJ. NO. 96968.3		SHEET 62	



NOTICE: When Government drawings, specifications, or other data are used for any purpose other than in connection with a definitely related Government procurement operation, the United States Government hereby incurs no responsibility or obligation whatsoever, and the fact that the Government may have formulated, furnished, or in any way supplied the said drawings, specifications or other data is not to be regarded by implication or otherwise as in any manner licensing the holder or any other person or corporation, or conveying any rights or permission to manufacture, use, or sell any patented invention that may in any way be related thereto.

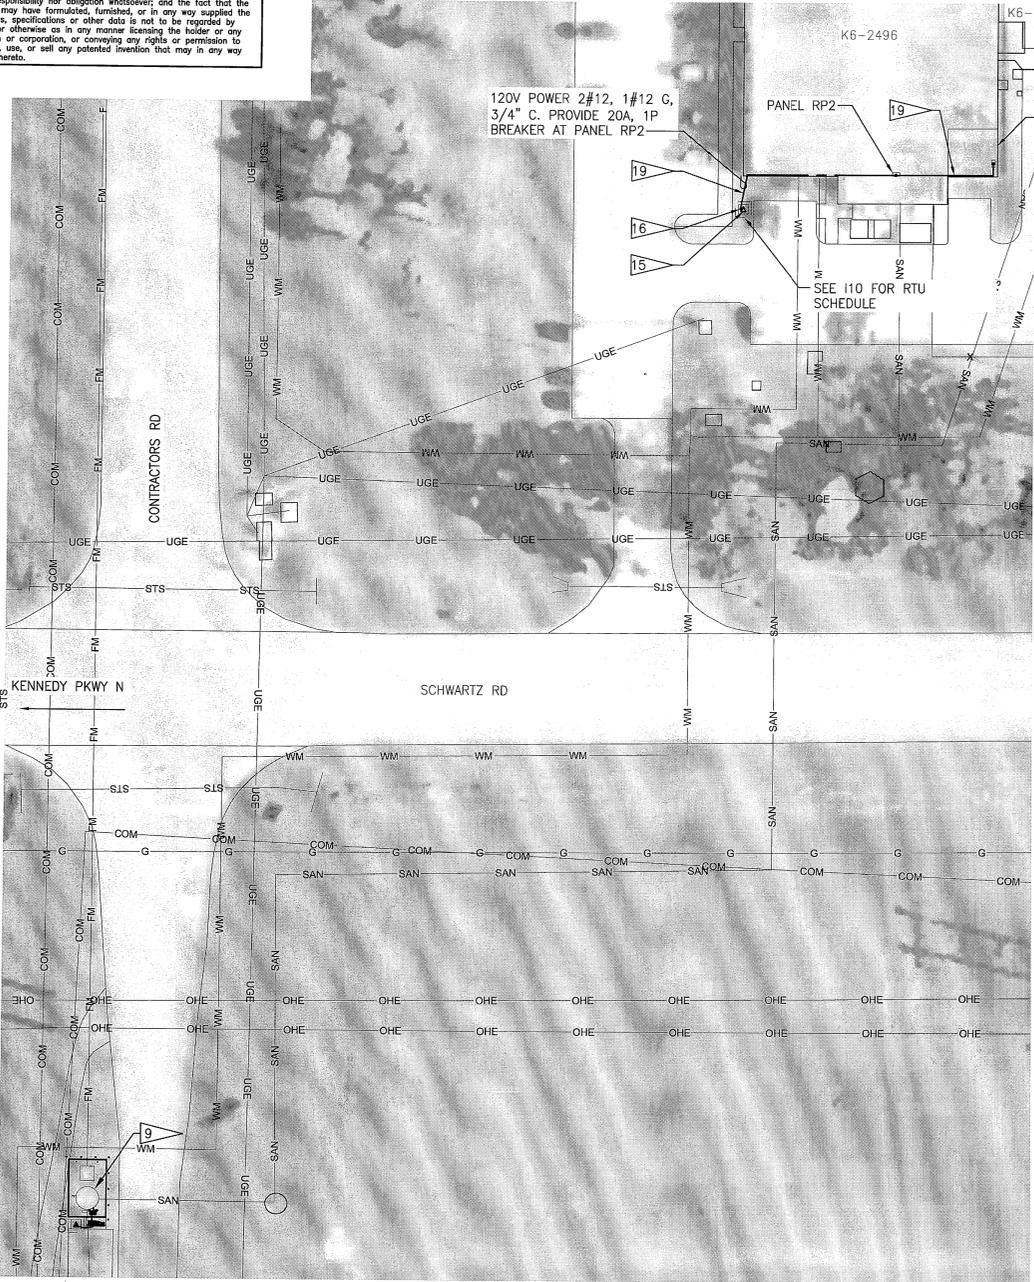


LIFT STATION LS-401 PLAN
1"=30'

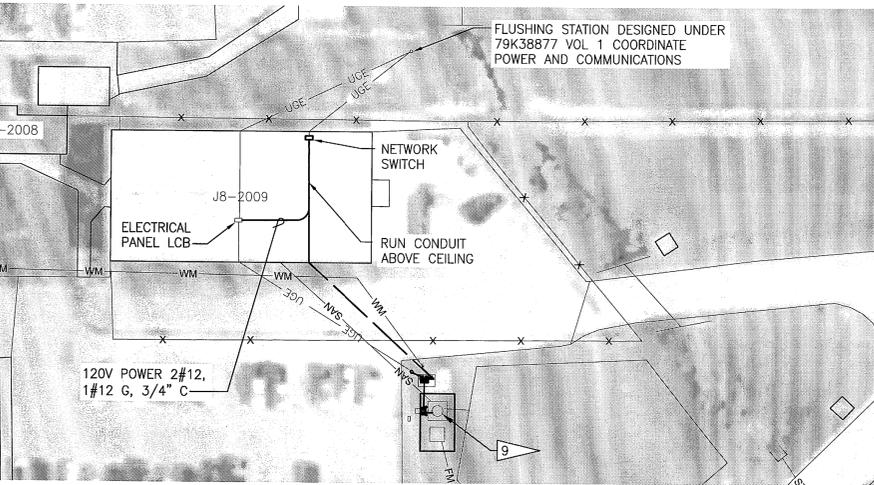


LIFT STATION LS-5E2 PLAN
1"=30'

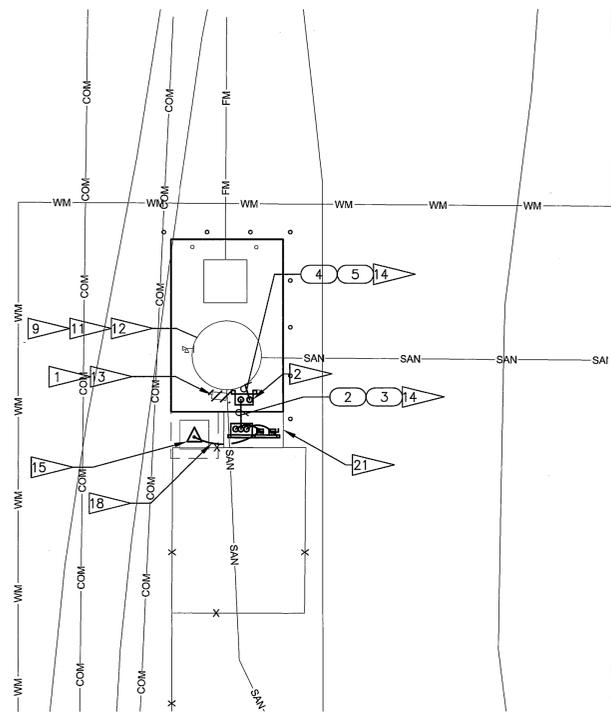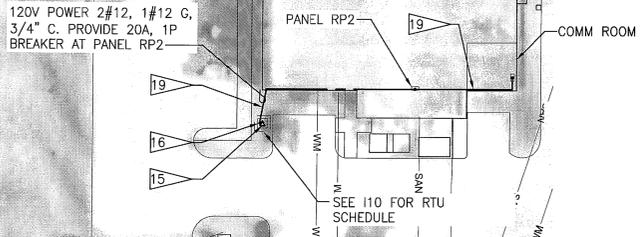


LIFT STATION LS-401 PLAN
1"=10'

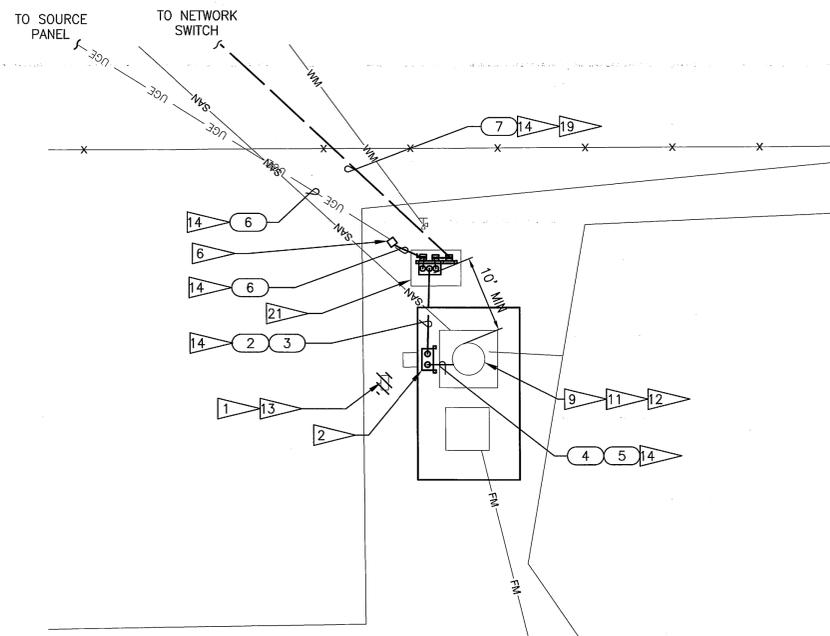




LIFT STATION LS-5E2 PLAN
1"=10'

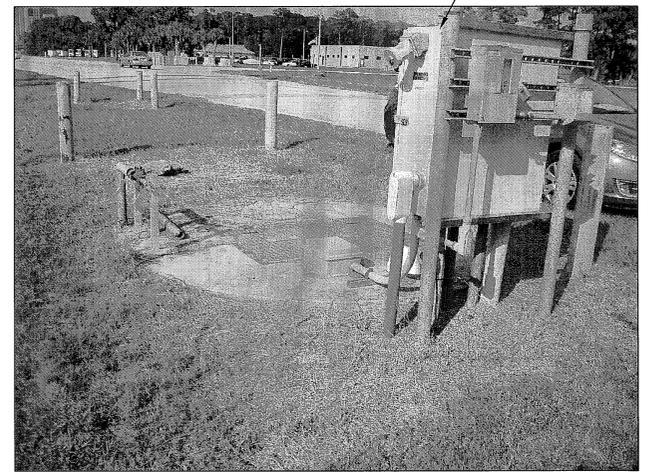

LIFT STATION LS-401 PHOTO
NTS

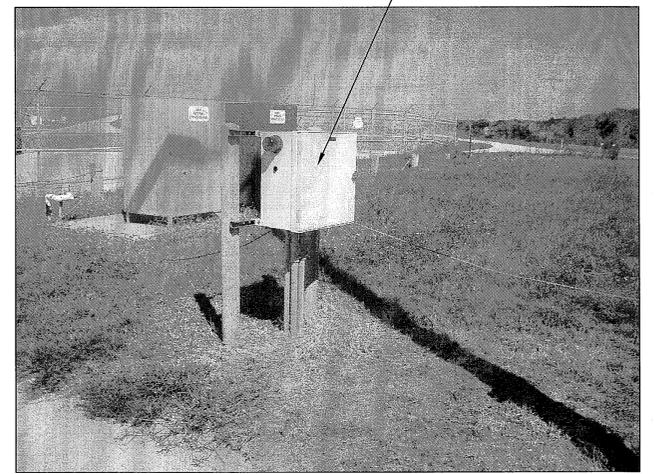


LIFT STATION LS-5E2 PHOTO
NTS

 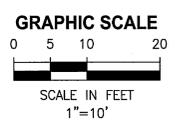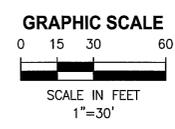


THIS SPACE RESERVED			
A	GENERAL REVISIONS	10/31/11	KM
SYM	ZONE	DESCRIPTION	DATE
REVISIONS			
THIS DRAWING CREATED IN AUTOCAD 2010 FILE FORMAT AND WILL BE REVISED ONLY ON AN AUTOCAD SYSTEM. FILE: 14000189-0P2-E20.DWG			
<small>CERTIFICATE OF AUTHORIZATION #1841 730 NE WALDO ROAD, GAINESVILLE, FLORIDA 32641 / (352) 377-5821 3910 S WASHINGTON AVE, SUITE 210, TITUSVILLE, FLORIDA 32780 / (321) 269-2950</small>			
SIGNATURES		DATE	
DRAWN L MILLER		10/31/11	
CHECKED M KOROS		10/31/11	
SUBMITTED K CLARK		10/31/11	
ST of LICENSURE: FL LICENSE NO: 48898			
APPROVED K CLARK		10/31/11	
E20		11/11	
NATIONAL AERONAUTICS AND SPACE ADMINISTRATION JOHN F. KENNEDY SPACE CENTER, NASA KENNEDY SPACE CENTER, FLORIDA		REVITALIZE WATER & WASTEWATER SYSTEMS - VOLUME 2 OF 5 LIFT STATIONS LIFT STATIONS 401 AND 5E2 ELECTRICAL PLANS	
FILE NO.	SHEET	DWG. NO.	REV
PROJ. NO. 96968.3	F	79K38877 VOL 2	A
			SHEET 63


NOTICE: When Government drawings, specifications, or other data are used for any purpose other than in connection with a definitely related Government procurement operation, the United States Government thereby incurs no responsibility nor obligation whatsoever, and the fact that the Government may have formulated, furnished, or in any way supplied the said drawings, specifications or other data is not to be regarded as an implication or otherwise as in any manner licensing the holder or any other person or corporation, or conveying any rights or permission to manufacture, use, or sell any patented invention that may in any way be related thereto.

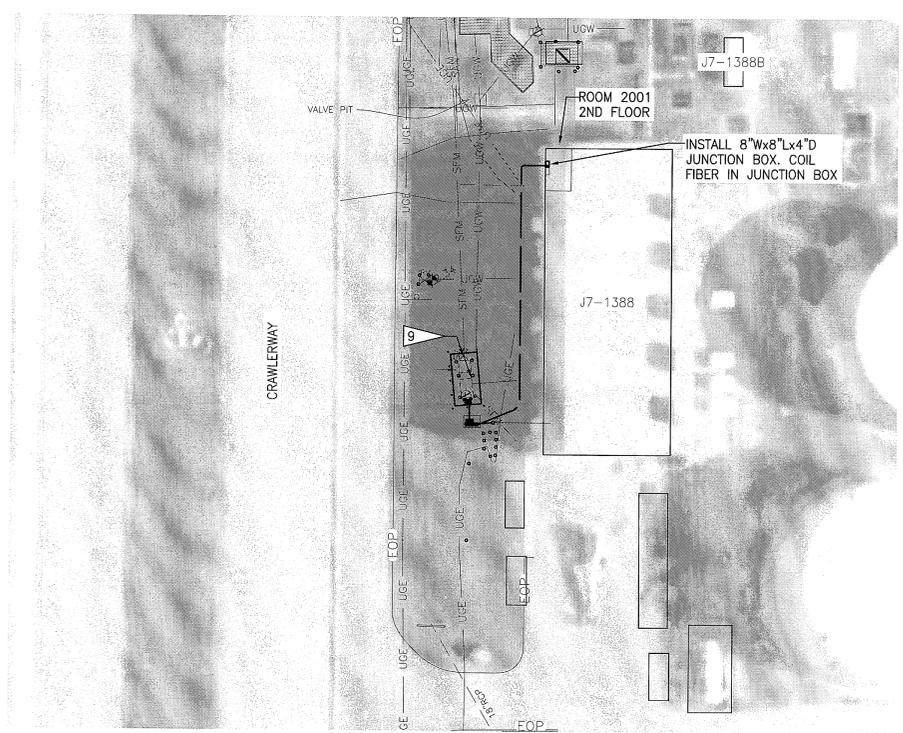


LIFT STATION LS-5D PLAN
1"=30'

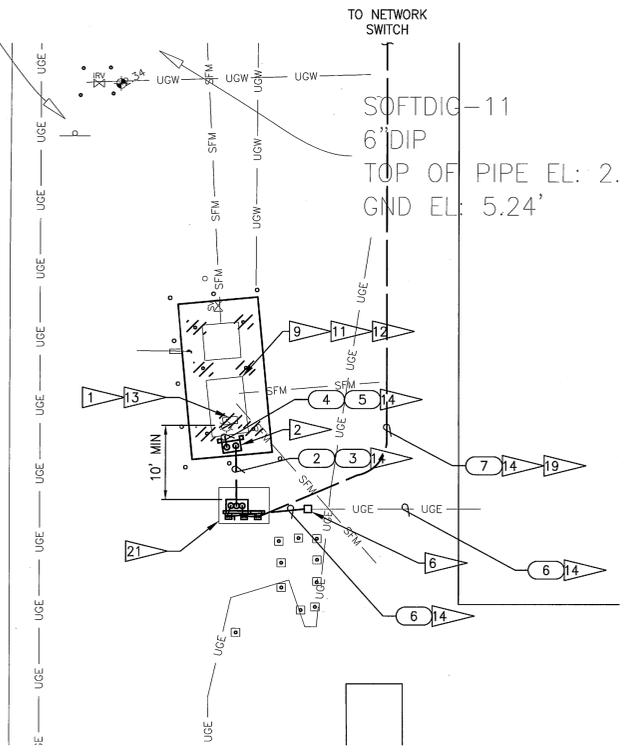


LIFT STATION LS-5D PLAN
1"=10'

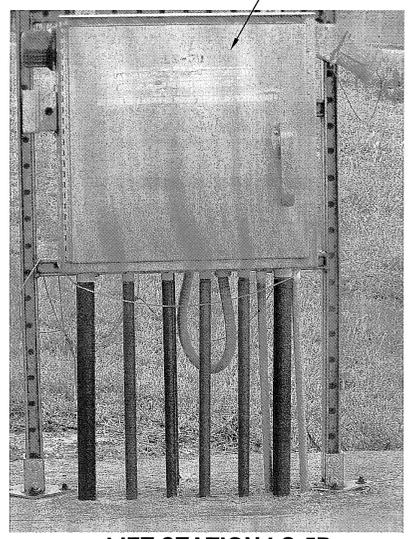


LIFT STATION LS-5D
NTS

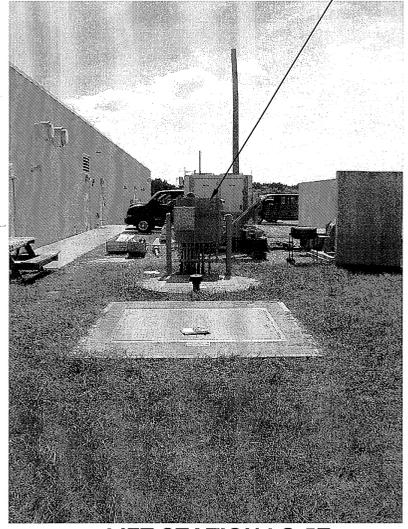



LIFT STATION LS-5E
NTS

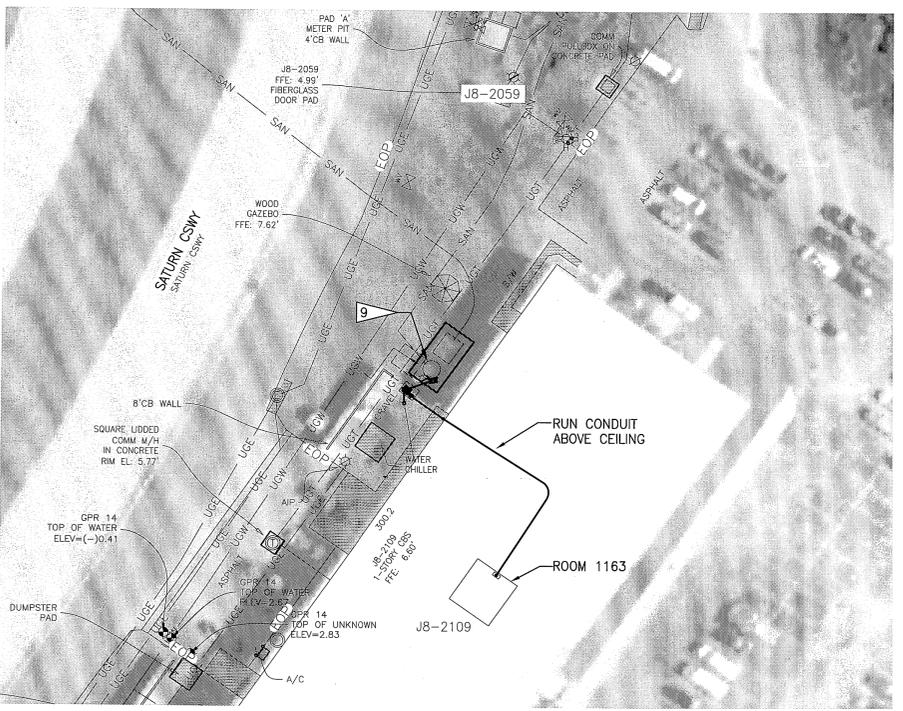

LIFT STATION LS-5E PLAN
1"=30'

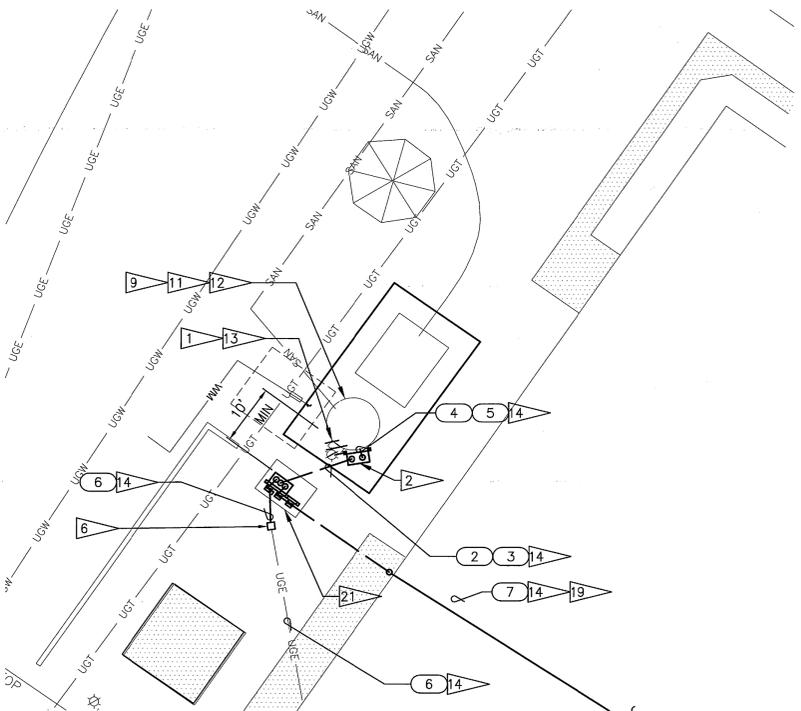


LIFT STATION LS-5E PLAN
1"=10'

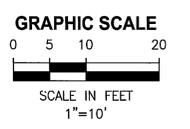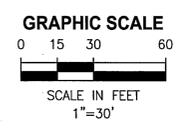


THIS SPACE RESERVED			
A	GENERAL REVISIONS	10/31/11	km
SYM	ZONE	DESCRIPTION	DATE
REVISIONS			
THIS DRAWING CREATED IN AUTOCAD 2010 FILE FORMAT AND WILL BE REVISED ONLY ON AN AUTOCAD SYSTEM. FILE: 14000189-DP2-E21.DWG			
<small>CERTIFICATE OF AUTHORIZATION #1841 730 NE WALDO ROAD, GAINESVILLE, FLORIDA 32641 / (352) 377-5821 3910 S WASHINGTON AVE, SUITE 210, TITUSVILLE, FLORIDA 32780 / (321) 269-2950</small>			
SIGNATURES		DATE	
DRAWN L. MILLER		10/31/11	
CHECKED M. KOROS		10/31/11	
SUBMITTED M. CLARK		10/31/11	
STATE OF FLORIDA LICENSE NO. 48898			
APPROVED M. CLARK		10/31/11	
D. CRAIG		11/1/11	
NATIONAL AERONAUTICS AND SPACE ADMINISTRATION JOHN F. KENNEDY SPACE CENTER, NASA KENNEDY SPACE CENTER, FLORIDA		REVITALIZE WATER & WASTEWATER SYSTEMS - VOLUME 2 OF 5 LIFT STATIONS LIFT STATIONS 5D AND 5E ELECTRICAL PLANS	
FILE NO.	SIZE	DWG. NO.	REV
E21	F	79K38877 VOL 2	A
PROJ. NO. 96968.3		SHEET 64	


NOTICE: When Government drawings, specifications, or other data are used for any purpose other than in connection with a definitely related Government procurement operation, the United States Government hereby incurs no responsibility or obligation whatsoever and the fact that the Government may have formulated, furnished, or in any way supplied the said drawings, specifications or other data is not to be regarded by any person or corporation, or conveying any rights or permission to manufacture, use, or sell any patented invention that may in any way be related thereto.

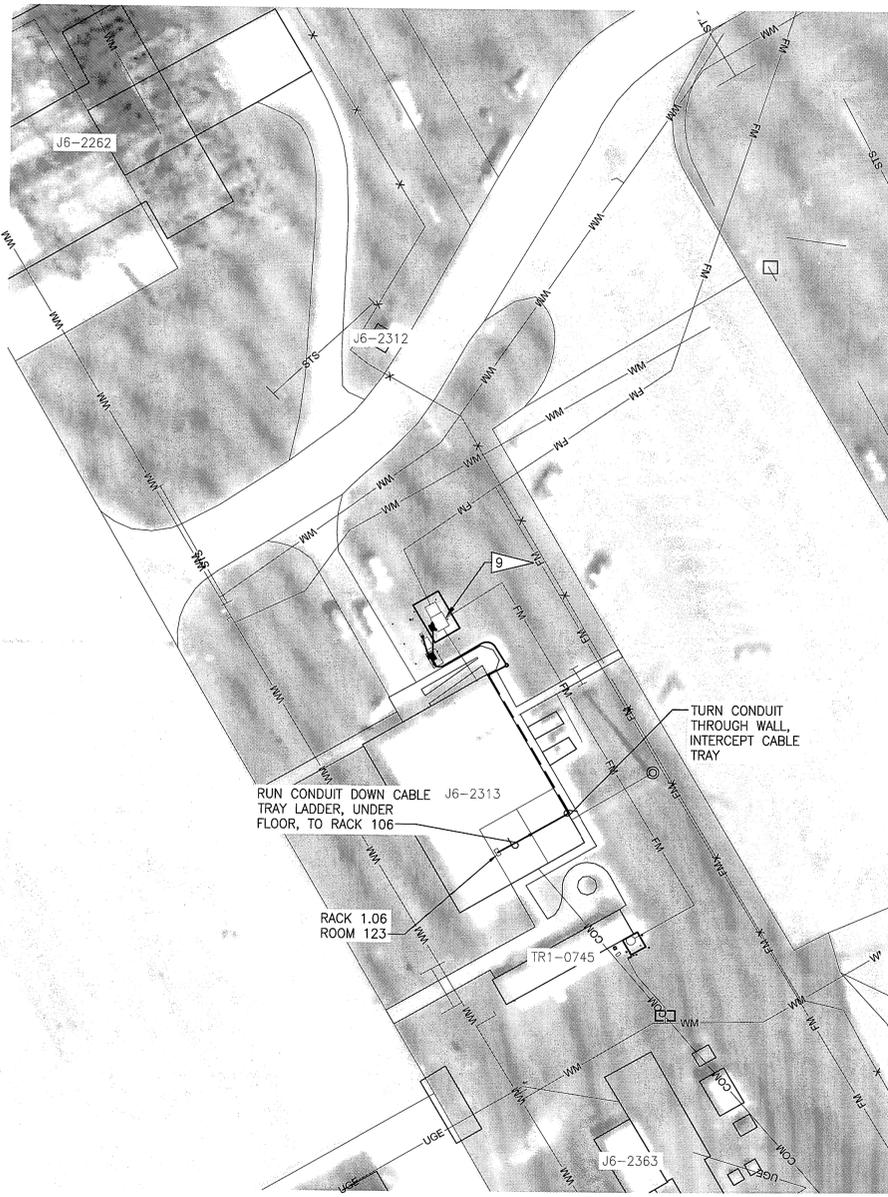




LIFT STATION LS-17A PLAN
1"=30'

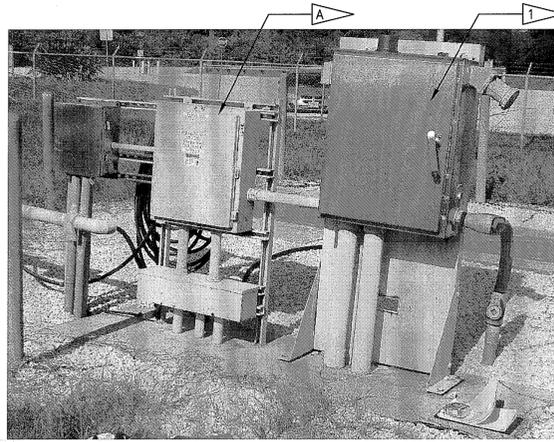

LIFT STATION LS-17A PHOTO
NTS

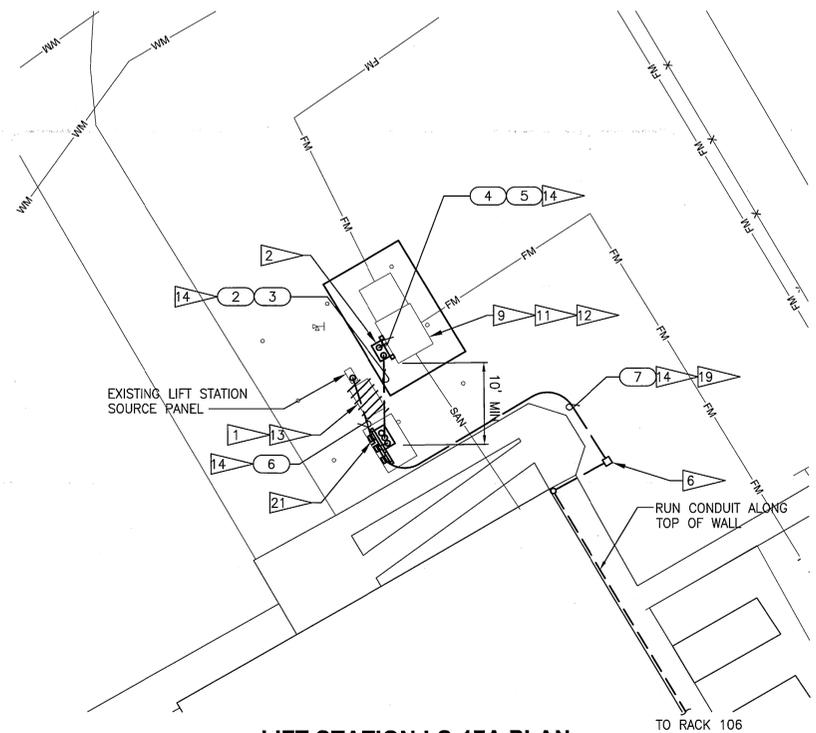


LIFT STATION LS-17A PLAN
1"=10'

 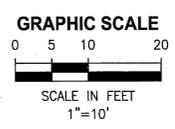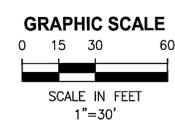


A		GENERAL REVISIONS		10/31/11	<i>km</i>
SYM	ZONE	DESCRIPTION	DATE	APPROVED	
REVISIONS					
THIS DRAWING CREATED IN AUTOCAD 2010 FILE FORMAT AND WILL BE REVISED ONLY ON AN AUTOCAD SYSTEM. FILE: 14000189-0P2-E22.DWG					
JONES EDMUNDS					
CERTIFICATE OF AUTHORIZATION #1941 730 NE WALDO ROAD, GAINESVILLE, FLORIDA 32641 / (352) 377-5821 3910 S WASHINGTON AVE, SUITE 210, TITUSVILLE, FLORIDA 32780 / (321) 269-2950					
SIGNATURES		DATE		NATIONAL AERONAUTICS AND SPACE ADMINISTRATION JOHN F. KENNEDY SPACE CENTER, NASA KENNEDY SPACE CENTER, FLORIDA	
DRAWN L. MILLER		10/31/11		REVITALIZE WATER & WASTEWATER SYSTEMS - VOLUME 2 OF 5 LIFT STATIONS LIFT STATIONS 17A ELECTRICAL PLAN	
CHECKED M. KOROS		10/31/11			
SUBMITTED <i>[Signature]</i>		10/31/11			
ST of LICENSURE: FL LICENSE NO: 48898					
APPROVED <i>[Signature]</i>		10/31/11		FILE NO.	SIZE DWG. NO.
E22		<i>[Signature]</i>		F	79K38877 VOL 2
PROJ. NO. 96968.3				SHEET 65	

NOTICE: When Government drawings, specifications, or other data are used for any purpose other than in connection with a definitely related Government procurement operation, the United States Government thereby incurs no responsibility nor obligation whatsoever, and the fact that the Government may have formulated, furnished, or in any way supplied the said drawings, specifications or other data is not to be regarded by implication or otherwise as in any manner licensing the holder or any other person or corporation, or conveying any rights or permission to manufacture, use, or sell any patented invention that may in any way be related thereto.

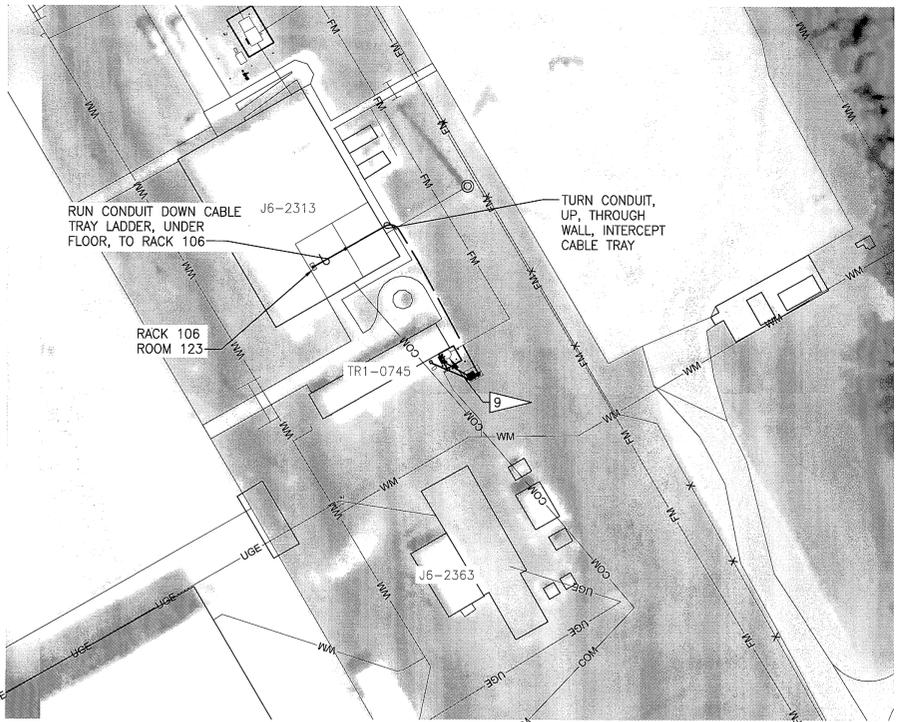


LIFT STATION LS-17C PLAN
1"=30'

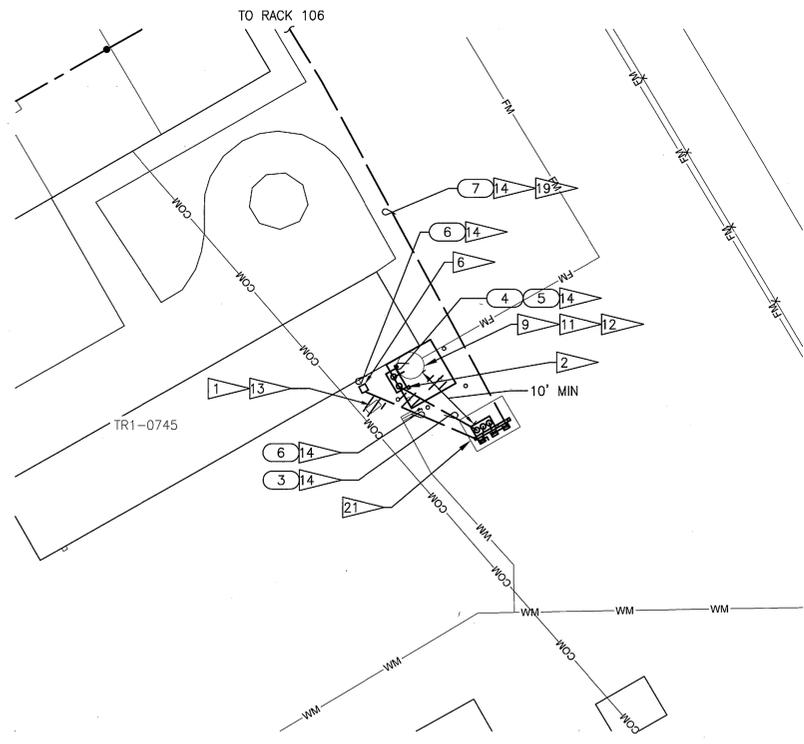


LIFT STATION LS-17C PLAN
1"=10'




LIFT STATION LS-17C PHOTO
NTS

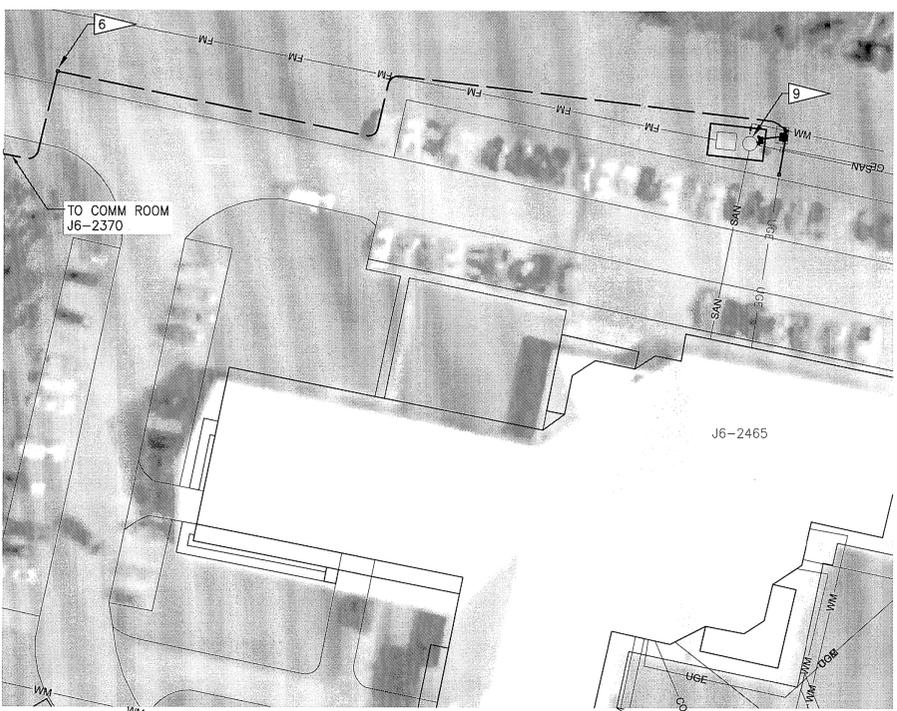


LIFT STATION LS-17D PLAN
1"=30'

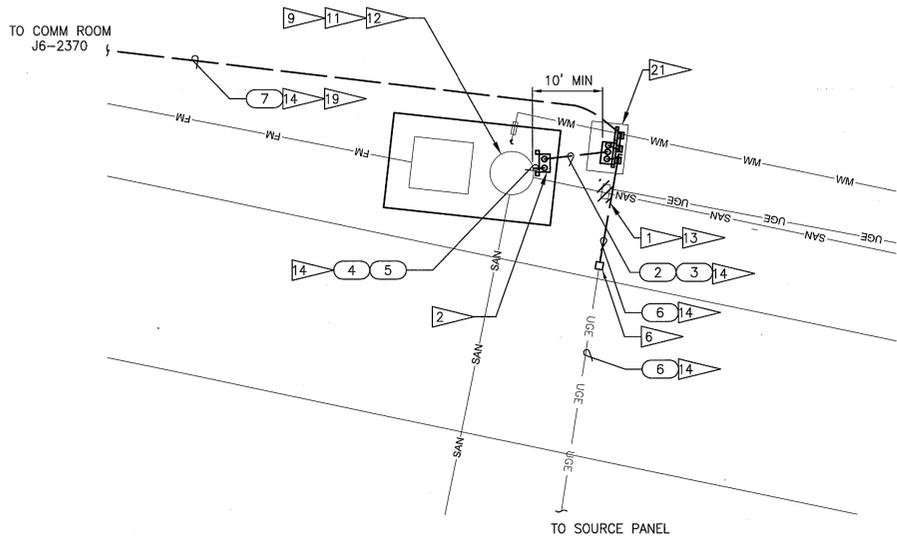

LIFT STATION LS-17D PLAN
1"=10'

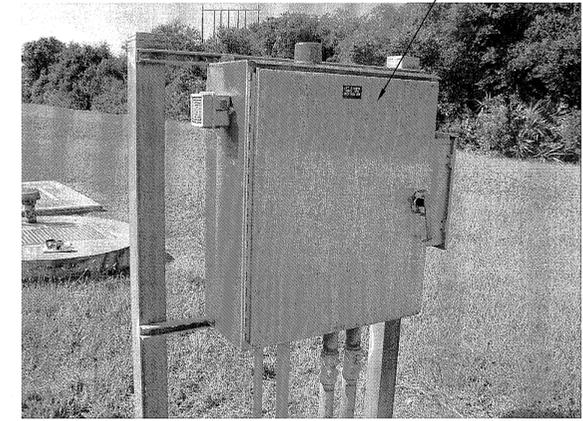


LIFT STATION LS-17D PHOTO
NTS

 


A		GENERAL REVISIONS		10/31/11	<i>km</i>
SYM	ZONE	DESCRIPTION	DATE	APPROVED	
REVISIONS					
THIS DRAWING CREATED IN AUTOCAD 2010 FILE FORMAT AND WILL BE REVISED ONLY ON AN AUTOCAD SYSTEM. FILE: 14000189-DP2-E23.DWG					
<small>CERTIFICATE OF AUTHORIZATION #1841 730 NE WALDO ROAD, GAINESVILLE, FLORIDA 32641 / (352) 377-5821 3910 S WASHINGTON AVE, SUITE 210, TITUSVILLE, FLORIDA 32780 / (321) 269-2950</small>					
SIGNATURES		DATE			
DRAWN		10/31/11			
CHECKED		10/31/11			
SUBMITTED		10/31/11			
ST of LICENSEURE: FL		LICENSE NO: 48898			
APPROVED		10/31/11			
 M. KOROS D. TRAVIS		 L. MILLER			
E23		FILE NO.		SIZE	DWG. NO.
		F		79K38877 VOL 2	REV A
		PROJ. NO. 96968.3		SHEET 66	


NOTICE: When Government drawings, specifications, or other data are used for any purpose other than in connection with a definitely related Government procurement operation, the United States Government thereby incurs no responsibility nor obligation whatsoever; and the fact that the Government may have formulated, furnished, or in any way supplied the said drawings, specifications or other data is not to be regarded by any person or corporation, or conveying any rights or permission to manufacture, use, or sell any patented invention that may in any way be related thereto.

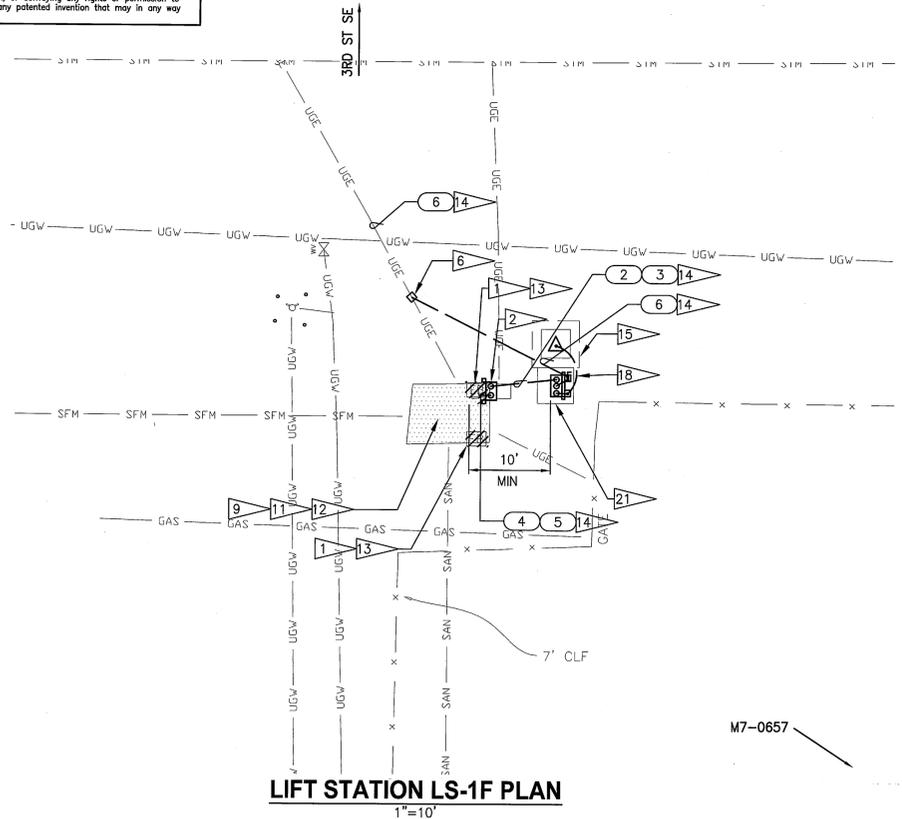


LIFT STATION LS-1F PLAN
1"=10'

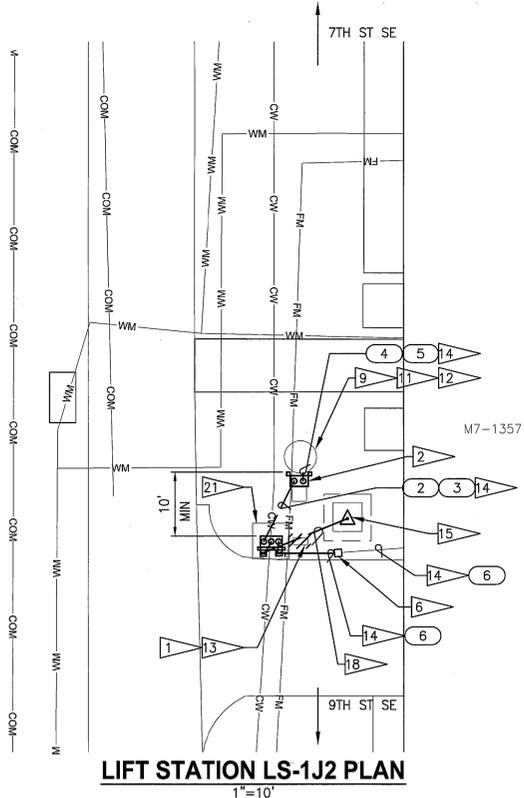



LIFT STATION LS-1J2 PLAN
1"=10'

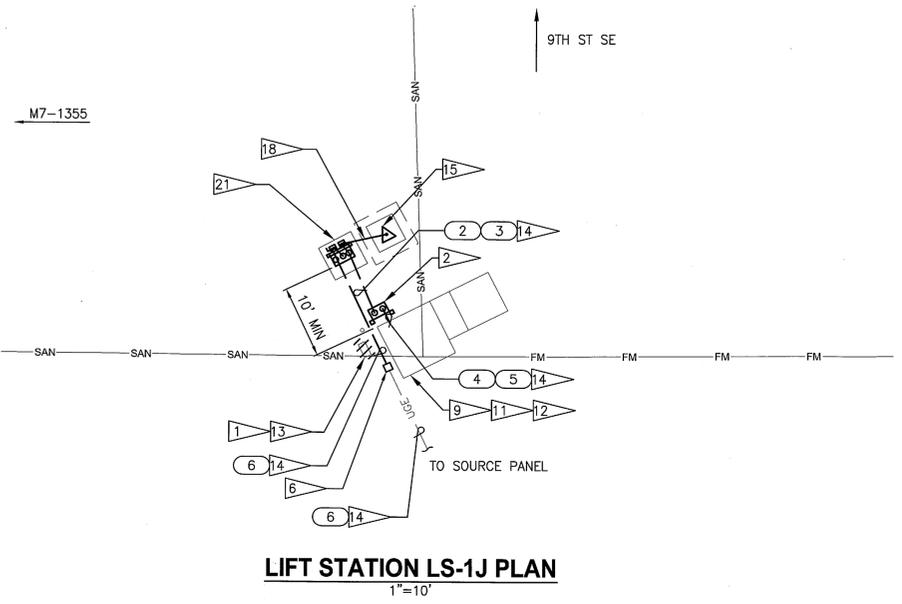

LIFT STATION LS-1J PLAN
1"=10'

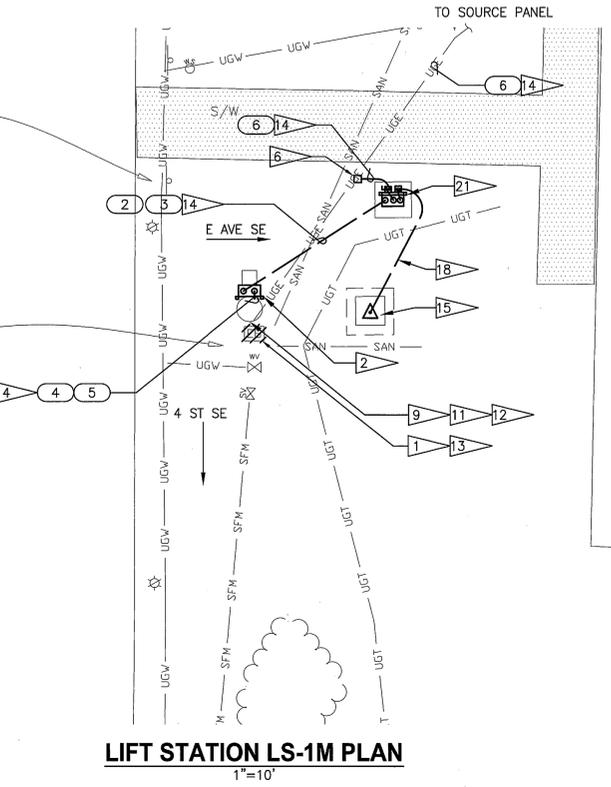

LIFT STATION LS-1M PLAN
1"=10'

 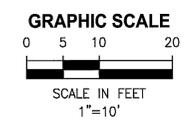

THIS SPACE RESERVED

SYM	ZONE	GENERAL REVISIONS	DESCRIPTION	DATE	APPROVED
				10/31/11	<i>W</i>

THIS DRAWING CREATED IN AUTOCAD 2010 FILE FORMAT AND WILL BE REVISED ONLY ON AN AUTOCAD SYSTEM. FILE: 14000189-DP2-E24.DWG

JONES EDMUNDS
CERTIFICATE OF AUTHORIZATION #1841
 730 NE WALDO ROAD, GAINESVILLE, FLORIDA 32641 / (352) 377-5821
 3910 S WASHINGTON AVE, SUITE 210, TITUSVILLE, FLORIDA 32780 / (321) 269-2950


SIGNATURES	DATE	NATIONAL AERONAUTICS AND SPACE ADMINISTRATION
DRAWN L MILLER	10/31/11	JOHN F. KENNEDY SPACE CENTER, NASA KENNEDY SPACE CENTER, FLORIDA
CHECKED M KOROS	10/31/11	REVITALIZE WATER & WASTEWATER SYSTEMS - VOLUME 2 OF 5 LIFT STATIONS LIFT STATIONS 1F, 1J, 1J2, AND 1M ELECTRICAL PLANS
SUBMITTED K CLARK	10/31/11	
ST of LICENSURE: FL LICENSE NO: 48898		
APPROVED K CLARK	10/31/11	FILE NO.
<i>[Signature]</i>	11/1/11	SIZE F
		DWG. NO. 79K38877 VOL 2
		REV A
		PROJ. NO. 96968.3
		SHEET 67

NOTICE: When Government drawings, specifications, or other data are used for any purpose other than in connection with a definitely related Government procurement operation, the United States Government thereby incurs no responsibility or obligation whatsoever; and the fact that the Government may have formulated, furnished, or in any way supplied the said drawings, specifications or other data is not to be regarded as an implication or otherwise as in any manner licensing the holder or any other person or corporation, or conveying any rights or permission to manufacture, use, or sell any patented invention that may in any way be related thereto.


NOTES:

A SEE DETAIL 1 E25 SIMILAR. REPLACE CONTROL


PANEL IN SAME LOCATION AS EXISTING. MOUNT PROPOSED EQUIPMENT USING STAINLESS STEEL HARDWARE AND UNISTRUT AS REQUIRED. TEMPORARILY SHUT DOWN GUARD SHACK WATER SERVICE AS REQUIRED.

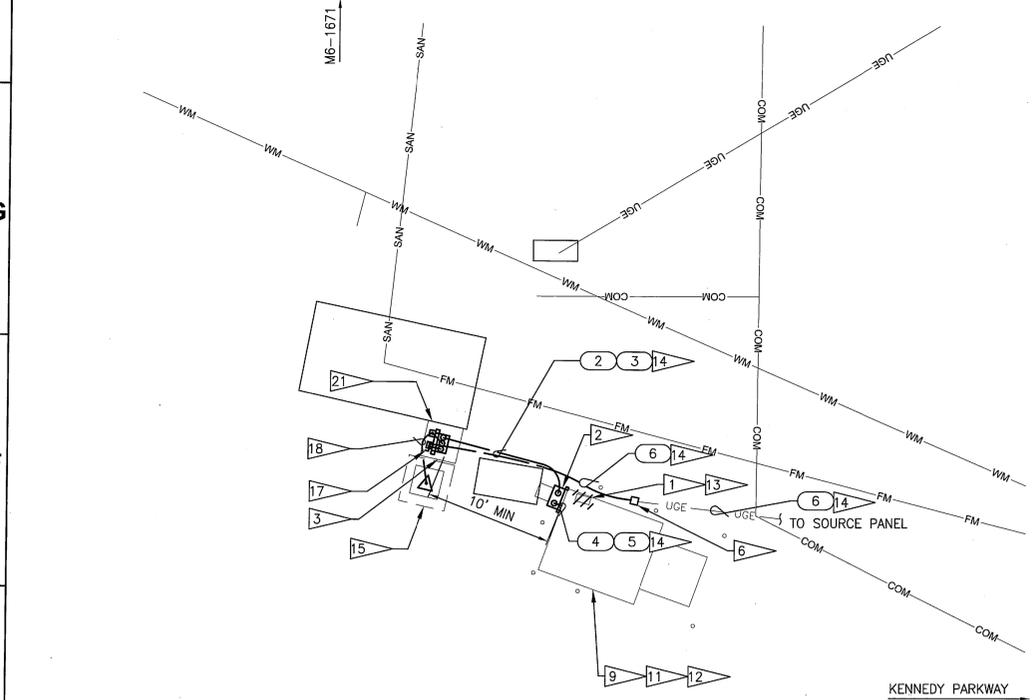


LIFT STATION LS-10 PLAN
1"=10'

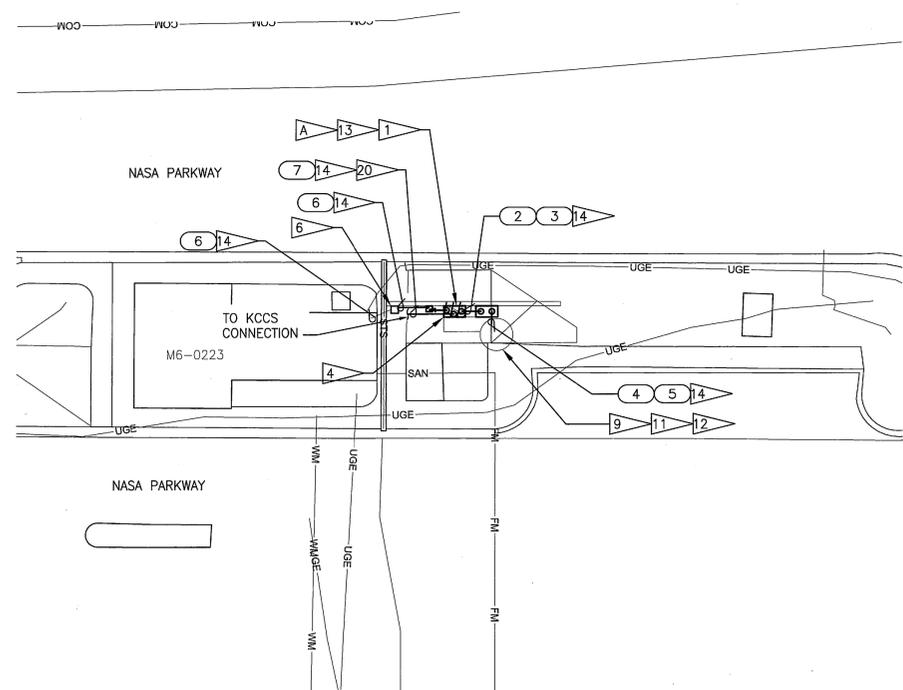



LIFT STATION LS-1R PLAN
1"=10'

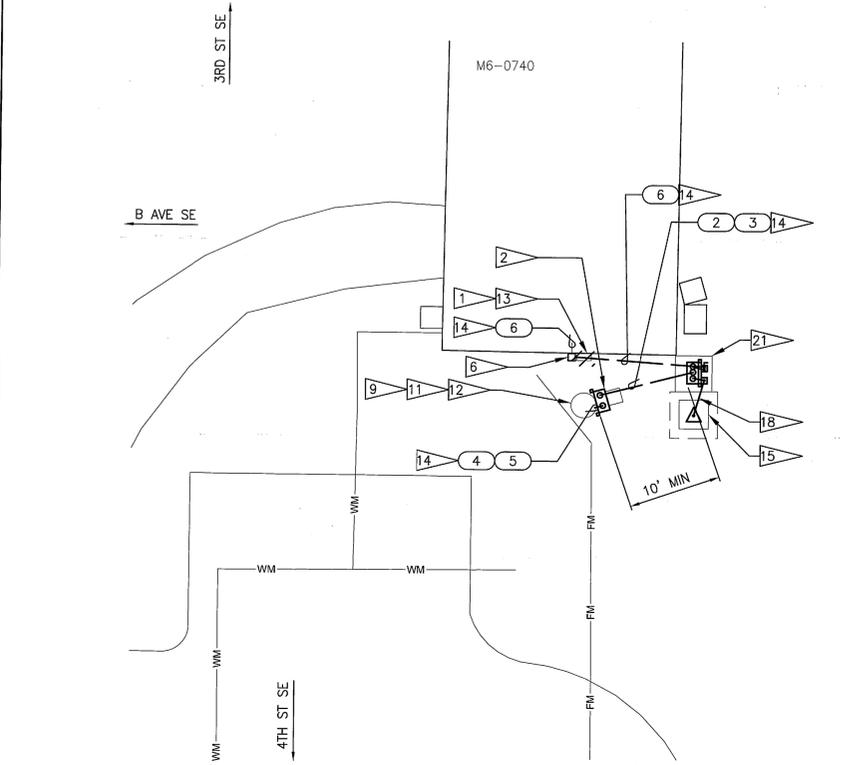

LIFT STATION LS-1Q PLAN
1"=10'

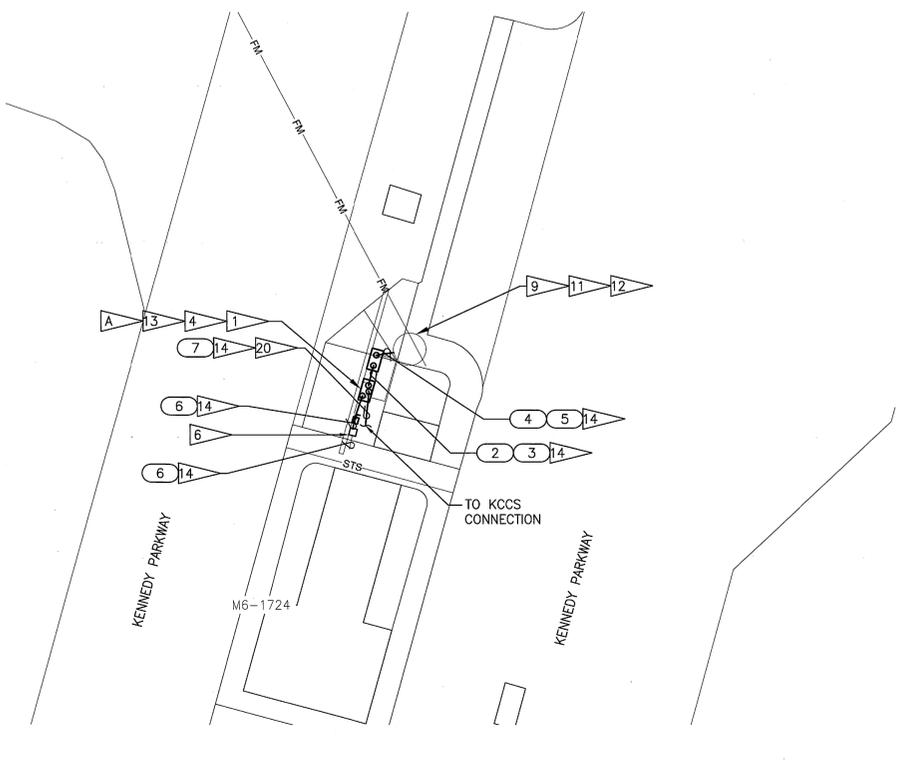


LIFT STATION LS-1S PLAN
1"=10'

 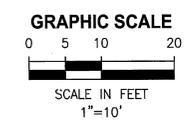


THIS SPACE RESERVED			
A	GENERAL REVISIONS	10/31/11	<i>[Signature]</i>
SYM	ZONE	DESCRIPTION	DATE
REVISIONS			
THIS DRAWING CREATED IN AUTOCAD 2010 FILE FORMAT AND WILL BE REVISED ONLY ON AN AUTOCAD SYSTEM. FILE: 14000189-DP2-E25.DWG			
<small>CERTIFICATE OF AUTHORIZATION #1841 730 NE WALDO ROAD, GAINESVILLE, FLORIDA 32641 / (352) 377-5821 3910 S WASHINGTON AVE, SUITE 210, TITUSVILLE, FLORIDA 32780 / (321) 269-2950</small>			
SIGNATURES		DATE	
DRAWN L MILLER		10/31/11	
CHECKED M KOROS		10/31/11	
SUBMITTED M CLARK		10/31/11	
ST of LICENSURE: FL LICENSE NO: 48898			
APPROVED M CLARK		10/31/11	
E25		<i>[Signature]</i>	
NATIONAL AERONAUTICS AND SPACE ADMINISTRATION JOHN F. KENNEDY SPACE CENTER, NASA KENNEDY SPACE CENTER, FLORIDA		REVOLVING WATER & WASTEWATER SYSTEMS - VOLUME 2 OF 5 LIFT STATIONS LIFT STATIONS 10,1Q,1R, AND 1S ELECTRICAL PLANS	
FILE NO.	SIZE F	DWG. NO. 79K38877 VOL 2	REV A
PROJ. NO. 96968.3		SHEET 68	

NOTICE: When Government drawings, specifications, or other data are used for any purpose other than in connection with a definitely related Government procurement operation, the United States Government thereby incurs no responsibility, not obligation whatsoever; and the fact that the Government may have formulated, furnished, or in any way supplied the said drawings, specifications or other data is not to be regarded by implication or otherwise as in any manner licensing the holder or any other person or corporation, or conveying any rights or permission to manufacture, use, or sell any patented invention that may in any way be related thereto.

NOTES:
 A LIFT STATION PHOTOGRAPHS ARE INTENDED FOR REFERENCE PURPOSES ONLY.

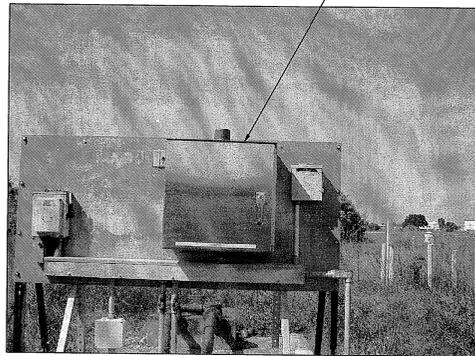


LIFT STATION LS-1F
NTS

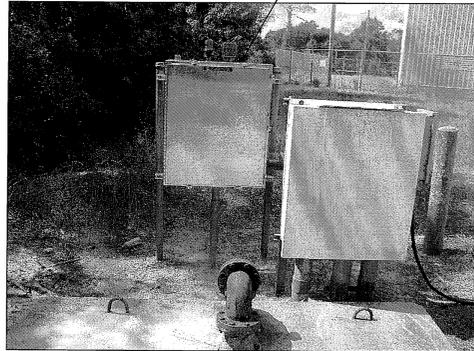


LIFT STATION LS-1J
NTS




LIFT STATION LS-1J2
NTS

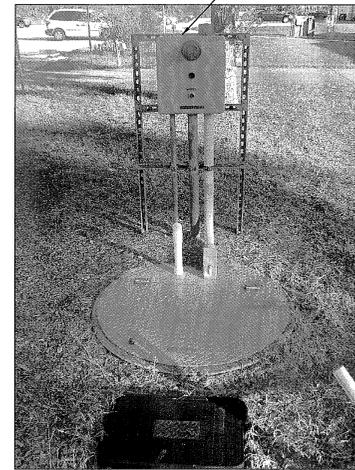


LIFT STATION LS-1M
NTS

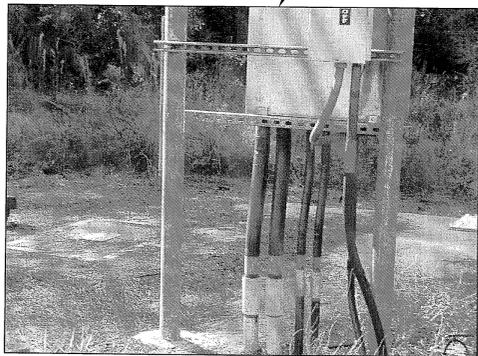

LIFT STATION LS-10
NTS

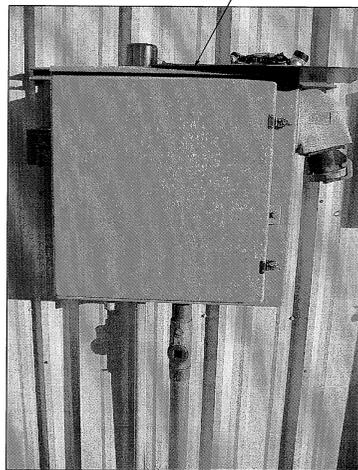

LIFT STATION LS-1Q CONTROL PANEL
NTS

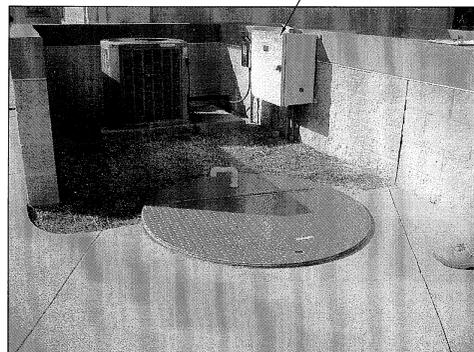

LIFT STATION LS-1R
NTS




LIFT STATION LS-1S
NTS

THIS SPACE RESERVED

SYM	ZONE	DESCRIPTION	DATE	APPROVED
A		GENERAL REVISIONS	12/05/11	<i>LM</i>

 THIS DRAWING CREATED IN AUTOCAD 2010 FILE FORMAT AND WILL BE REVISED ONLY ON AN AUTOCAD SYSTEM. FILE: 14000189-DP2-E26.DWG



SIGNATURES		DATE	NATIONAL AERONAUTICS AND SPACE ADMINISTRATION JOHN F. KENNEDY SPACE CENTER, NASA KENNEDY SPACE CENTER, FLORIDA	
DRAWN L MILLER		12/05/11	REVITALIZE WATER & WASTEWATER SYSTEMS - VOLUME 2 OF 5 LIFT STATIONS LIFT STATIONS 1F,1J,1J2,1M,10,1Q,1R, AND 1S DEMOLITION PHOTOS	
CHECKED M KOROS		12/05/11		
SUBMITTED <i>[Signature]</i>		12/05/11		
ST of LICENSURE: FL LICENSE NO: 48898			FILE NO.	REV
APPROVED <i>[Signature]</i> M. CLARK		12/05/11	F	A
D. TRANG		12/5/11	PROJ. NO. 96968.3	SHEET 69

E26

